
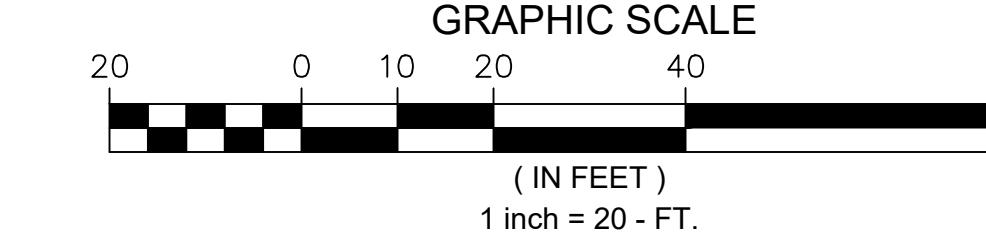


Luminaire Schedule							
Symbol	Qty	Label	Mounting Height	LLF	Lum. Lumens	Lum. Watts	Description
	7	A4	10' - 0" AFG	0.900	8822	70	ASL1-160L-70-3K7-4W-BC
	1	S4	16' - 0" AFG	0.900	8822	70	ASL1-160L-70-3K7-4W-BC

Calculation Summary								
Label	CalcType	Units	Avg	Max	Min	Avg/Min	Max/Min	
Overall Area	Illuminance	Fc	0.16	11.3	0.0	N.A.	N.A.	
Parking Area	Illuminance	Fc	1.74	11.3	0.0	N.A.	N.A.	

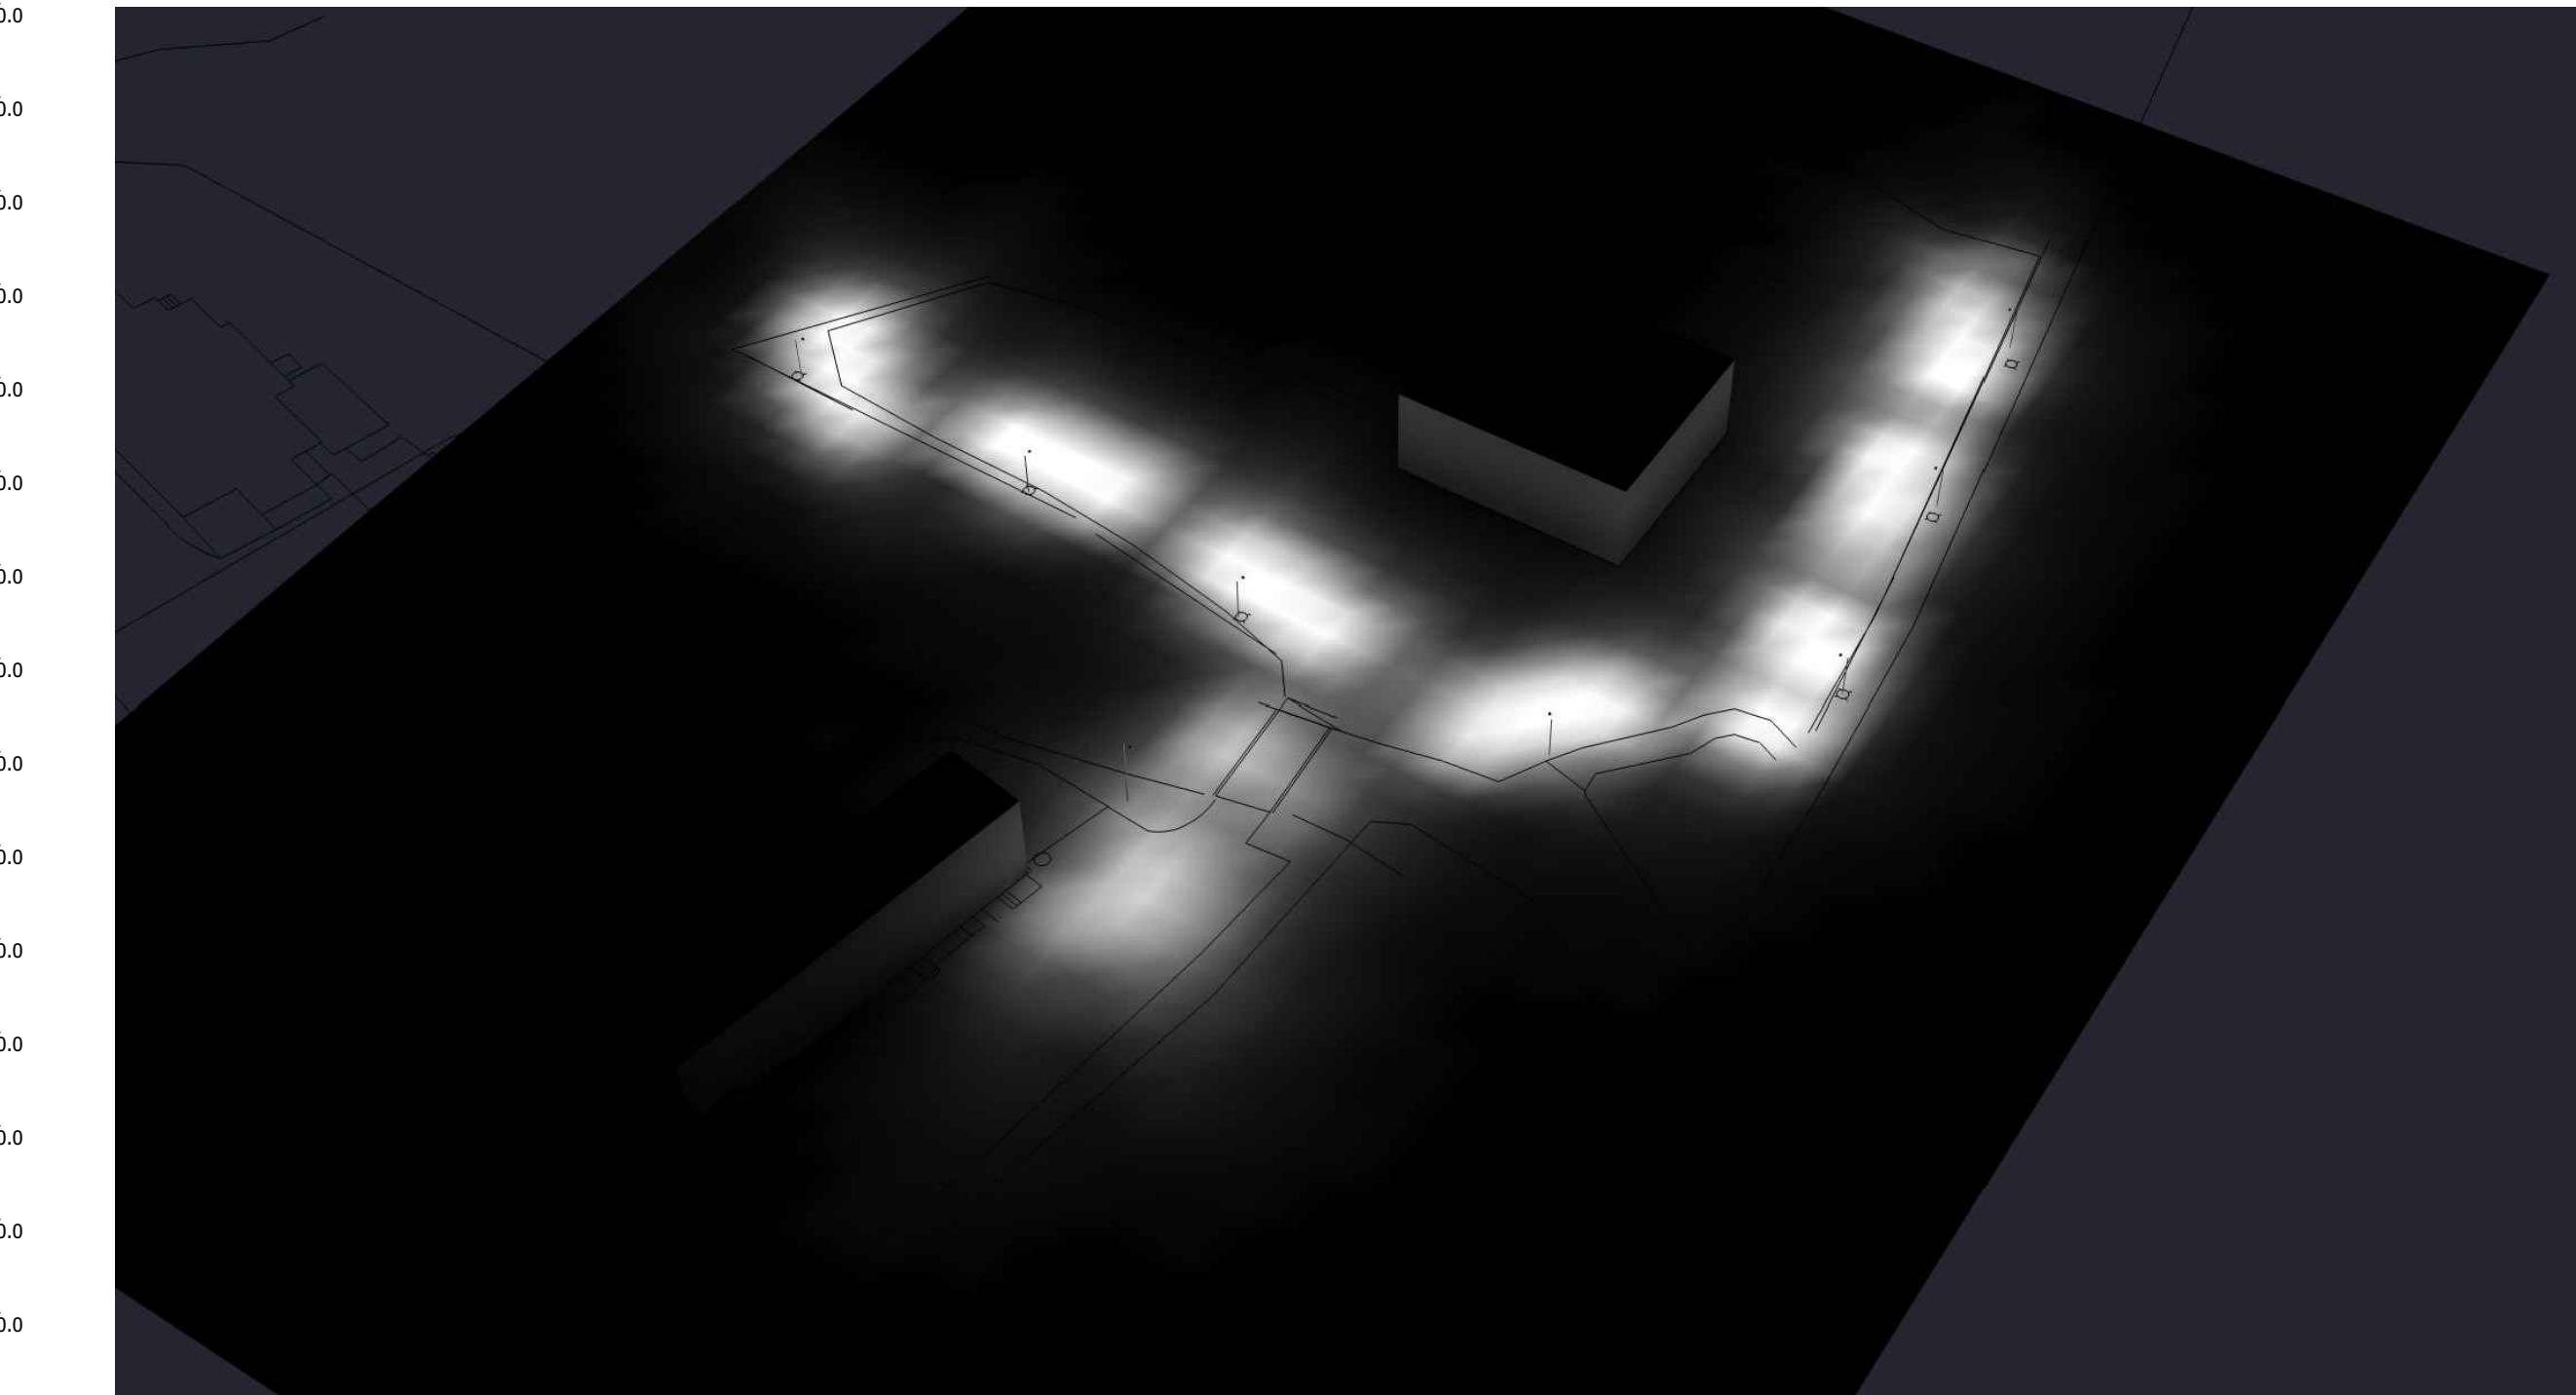

1. THIS LIGHTING DESIGN IS BASED ON LIMITED INFORMATION SUPPLIED BY OTHERS TO CURRENT. SITE DETAILS PROVIDED HEREON ARE REPRODUCED ONLY AS A VISUALIZATION AID. FIELD DEVIATIONS MAY SIGNIFICANTLY AFFECT PREDICTED PERFORMANCE. PRIOR TO INSTALLATION, CRITICAL SITE INFORMATION (POLE LOCATIONS, ORIENTATION, MOUNTING HEIGHT, ETC.) SHOULD BE COORDINATED WITH THE CONTRACTOR AND/OR SPECIFIER RESPONSIBLE FOR THE PROJECT.
2. LUMINAIRE DATA IS TESTED TO INDUSTRY STANDARDS UNDER LABORATORY CONDITIONS. OPERATING VOLTAGE AND NORMAL MANUFACTURING TOLERANCES OF LAMP, BALAST, AND LUMINAIRE MAY AFFECT FIELD RESULTS.
3. CONFORMANCE TO FACILITY CODE AND OTHER LOCAL REQUIREMENTS IS THE RESPONSIBILITY OF THE OWNER AND/OR THE OWNER'S REPRESENTATIVE.

TITLE:	REVISED FROM DRAWING NUMBER(S):
WHITE HORSE	R1: 04/12/23
NEW PRESTON, CT	R2: 04/14/23
SITE PHOTOMETRIC PLAN	
Current	DN BY: DHK DATE: 04/11/23 CHK BY: N/A
	REV BY: DHK DATE: 04/14/23 SCALE: AS NOTED
	QUOTE: N/A DRAWING / DESIGN NO.: A230544R2